



FAYETTEVILLE PUBLIC WORKS COMMISSION

FAYETTEVILLE, N.C.

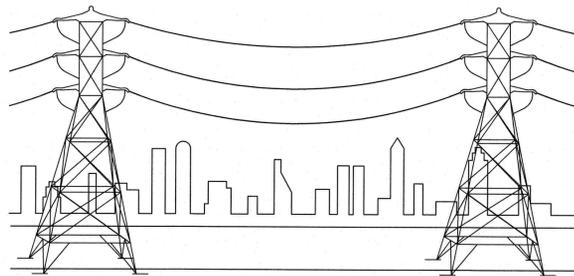


ELECTRICAL

JON RYNNE -ELEC. SYS. CHIEF OPER. OFFICER

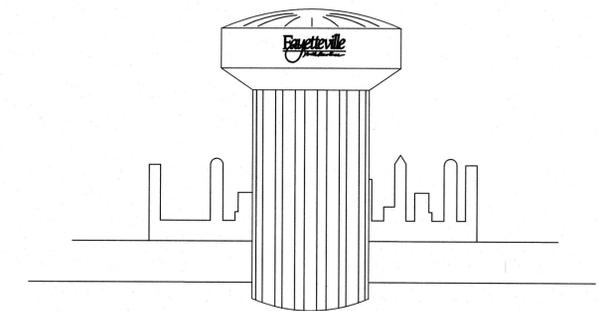

WATER RESOURCES

M.J. NOLAND -W/R CHIEF OPER. OFFICER
MISTY M. MANNING -W/R ENGR. MANAGER

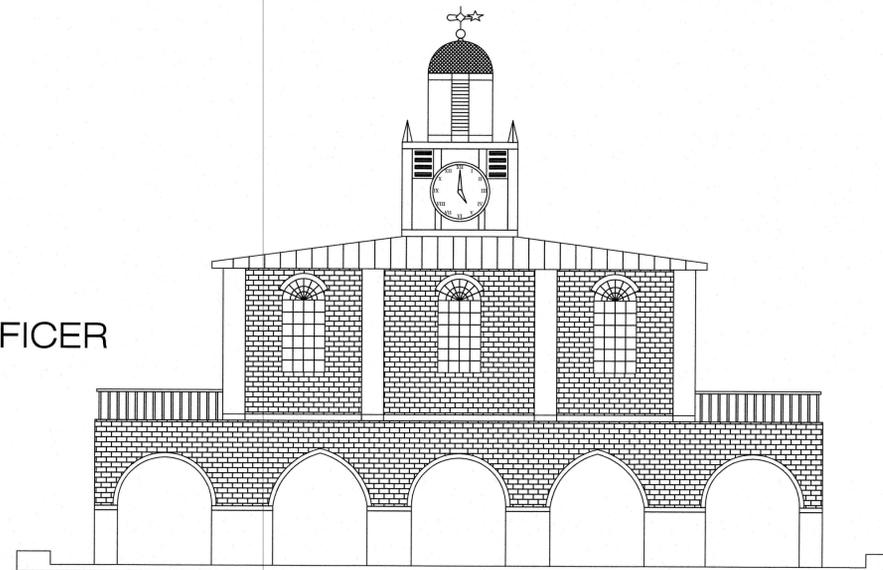

PWC COMMISSIONERS

Chairperson - **EVELYN O. SHAW**
Vice Chairperson - **RONNA ROWE GARRETT**
Secretary - **DONALD L. PORTER**
Treasurer - **WADE R. FOWLER, JR.**
CEO/General Manager - **ELAINA L. BALL**

SHEET INDEX

1	PWC COVER SHEET
2	S1 (PLAN AND PROFILE)
3	D1 (STANDARD DETAILS)



VICINITY MAP
N.T.S.




Know what's below.
Call before you dig.

RIVER ROAD

**SANITARY SEWER MANHOLE REPLACEMENT
AT CARGILL**




W:\ACTIVE PROJECTS\RIVER ROAD SANITARY SEWER MANHOLE REPLACEMENT AT CARGILL\REV 1.dwg, 4/11/2022 8:59:55 AM, AutoCAD PDF (General Documentation).plc3

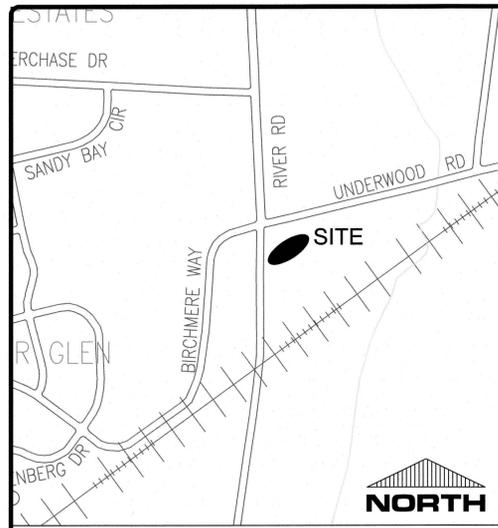



VICINITY MAP
(N.T.S.)

- UTILITY CONSTRUCTION NOTES:**
- ALL SEWER MAINS, LATERALS, AND APPURTENANCES SHALL BE INSTALLED AND TESTED IN ACCORDANCE WITH FAYETTEVILLE PWC STANDARDS.
 - ALL CONSTRUCTION TO BE IN ACCORDANCE WITH FAYETTEVILLE PWC STANDARDS.
 - CONTRACTOR SHALL FIELD VERIFY THE LOCATION OF EXISTING UTILITIES PRIOR TO CONSTRUCTION.
 - CONTRACTOR SHALL NOTIFY FAYETTEVILLE PWC A MINIMUM OF 48 HOURS IN ADVANCE FOR CONSTRUCTION STAKING. CONTRACTOR SHALL MAINTAIN A COPY OF THE CUT SHEET ON THE JOB SITE.
 - CONTRACTOR SHALL COORDINATE TESTING AND INSPECTION WITH THE FAYETTEVILLE PWC PROJECT COORDINATOR.
 - ALL NEW MANHOLES ARE TO BE VACUUM-TESTED IN ACCORDANCE WITH FAYETTEVILLE PWC STANDARDS.
 - CONTRACTOR SHALL COORDINATE AND COMPLY WITH ALL OF THE TRAFFIC CONTROL REQUIREMENTS OF THE CITY OF FAYETTEVILLE, N.C.D.O.T. AND THESE CONTRACT DOCUMENTS.
 - CONTRACTOR SHALL SAWCUT AND PATCH ALL ASPHALT AND CONCRETE DISTURBED BY CONSTRUCTION.
 - ALL NON-PAVED AREAS SHALL HAVE SOD INSTALLED, UNLESS OTHERWISE NOTED.
 - CONTRACTOR SHALL INSTALL AND MAINTAIN ALL NECESSARY EROSION CONTROL DEVICES IN ORDER TO PREVENT ANY SEDIMENT FROM ENTERING STORM DRAINS, DITCHES, ETC. ALL EROSION CONTROL DEVICES SHALL BE IN ACCORDANCE WITH N.C. DEPARTMENT OF ENVIRONMENTAL QUALITY REQUIREMENTS. NO SEPARATE PAYMENT.
 - CONTRACTOR SHALL REPLACE ALL DAMAGED WATER SERVICES FROM MAIN TO METER, UTILIZING #1 COPPER. WATER SERVICES SHALL BE INSTALLED IN ACCORDANCE WITH FAYPWC DETAIL W.24.

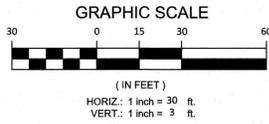

AERIAL PHOTOGRAPHY OF
PROPOSED WORK AREA
(N.T.S.)

LEGEND	
PROPERTY LINE	---
EDGE OF PAVEMENT	---
BACK OF CURB	---
STORM PIPE	---
EX. WATER MAIN	---
EX. SS MAIN	---
PROP. SS MAIN	---
PROP. WATER MAIN	---
EASEMENT	---
LIMITS OF DISTURBANCE	---
SILT FENCE	---
EX. UTIL. LINES	---
TREELINE	---
DITCH	---
EX./PROP. GATE VALVE	---
AIR RELEASE VALVE	---
CATCH BASIN/DROP INLET	---
EX./PROP. SSMH	---
EX./PROP. STORM MH	---
EX./PROP. UTILITY MH	---
GAS VALVE	---
EX./PROP. PLUG	---
EX./PROP. BLOW-OFF	---
POWER & LIGHT POLE/GUY WIRE	---
EX./PROP. WATER METER	---
EX./PROP. FIRE HYDRANT	---
UTILITY PEDESTALS	---
EX./PROP. CLEAN OUT	---
SIGNAL TRAFFIC BOX	---
MAILBOX	---
TREE/SHRUB	---

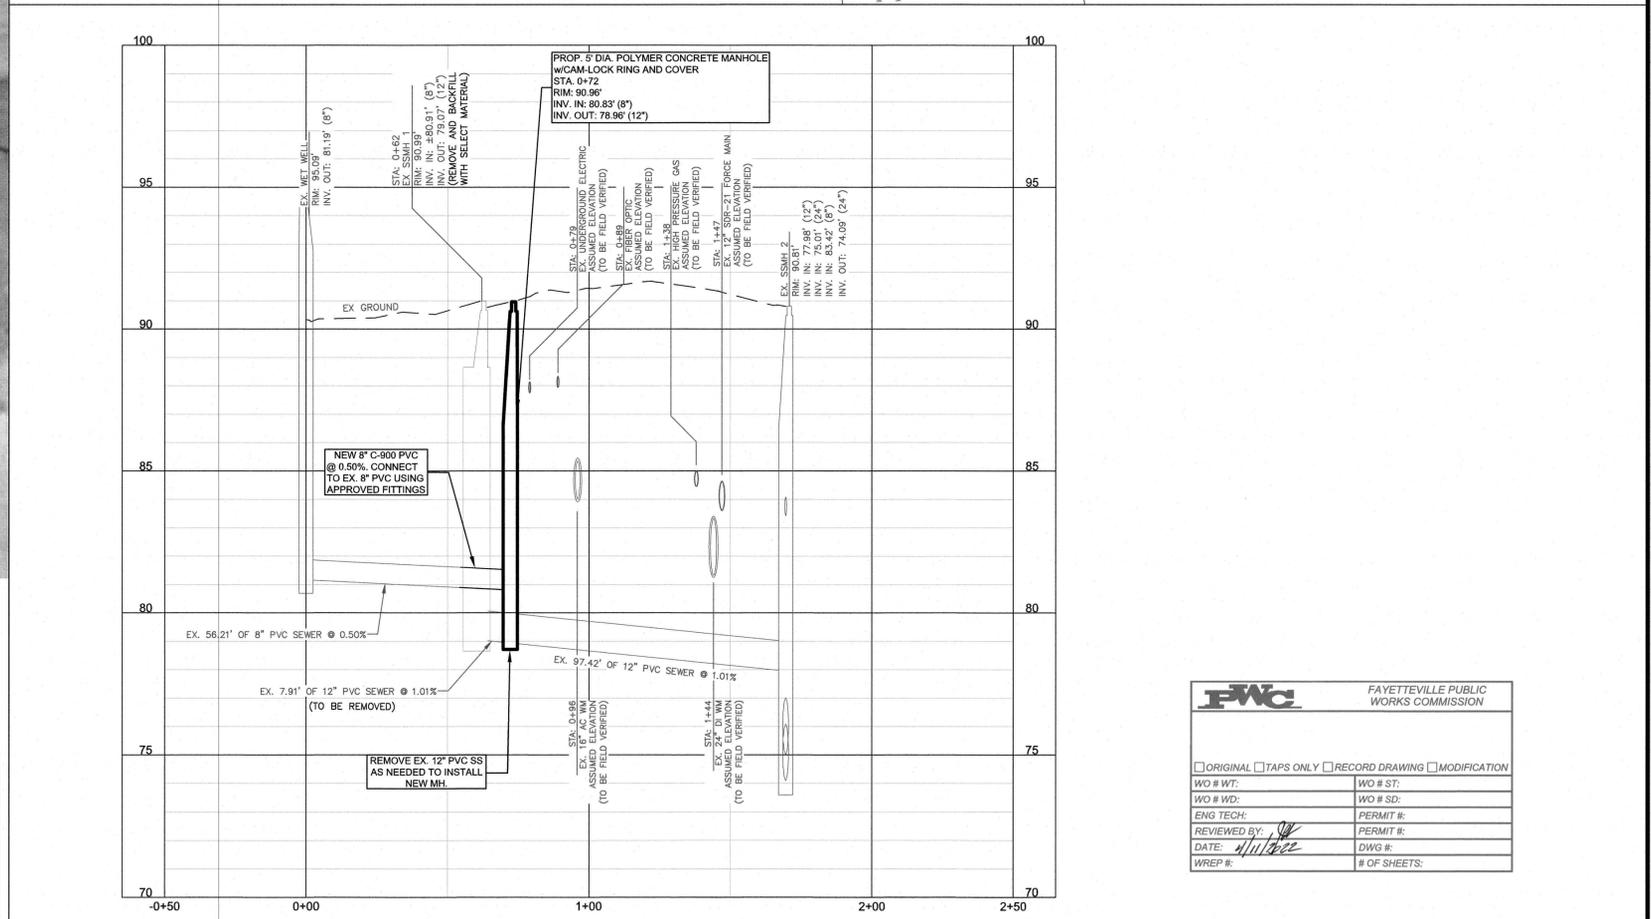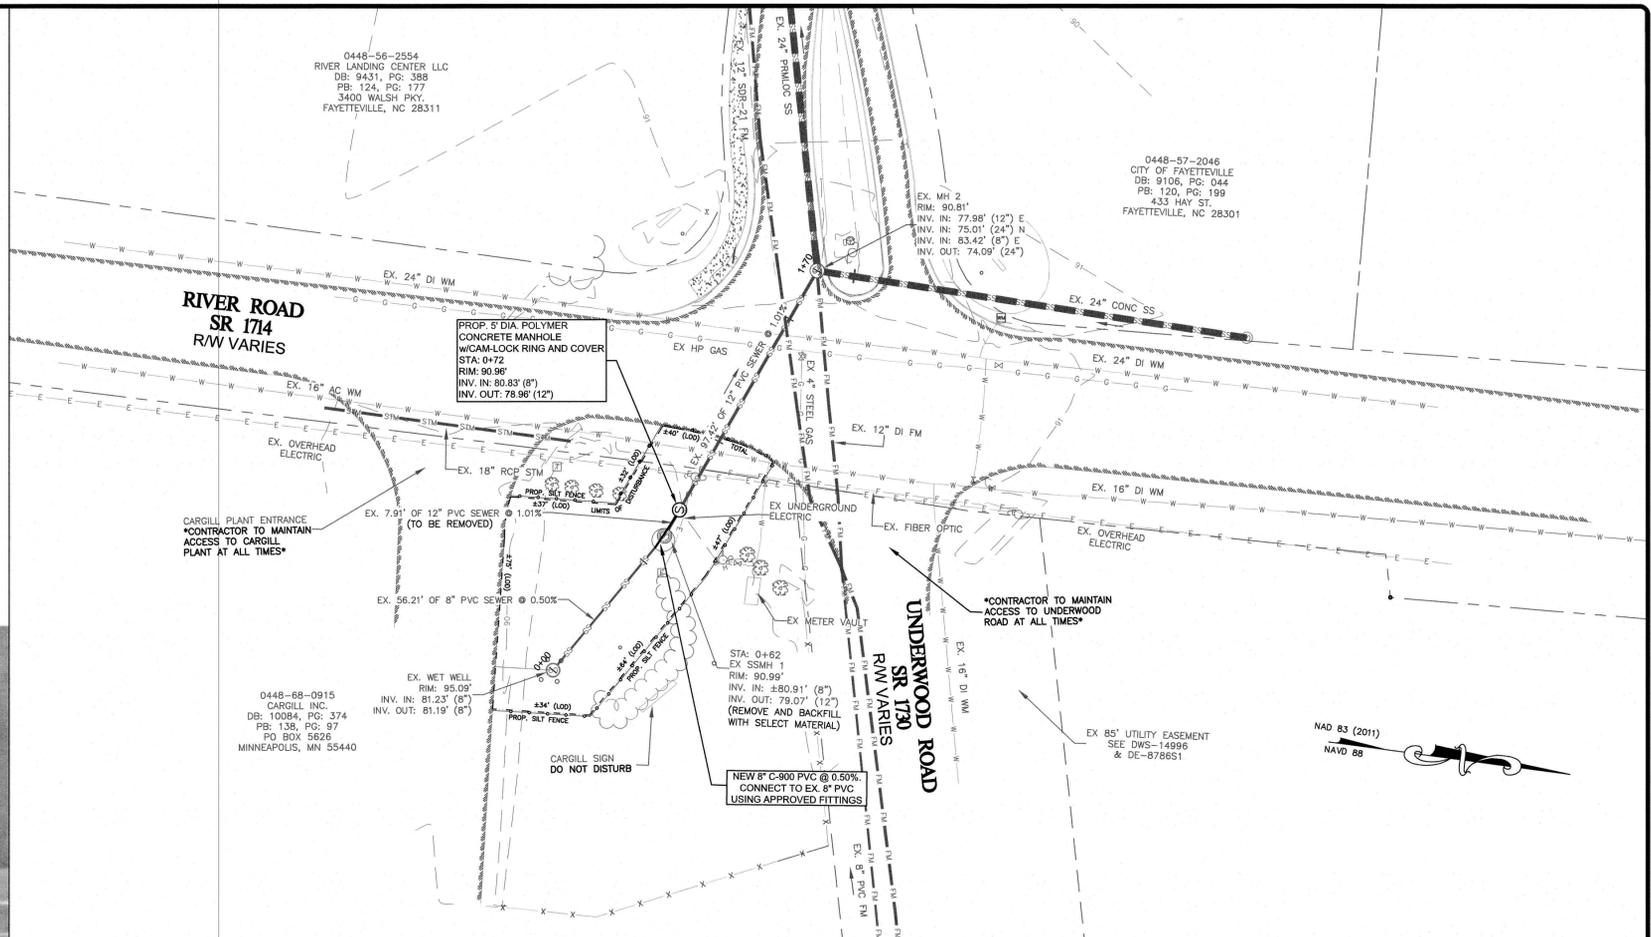

FWC FAYETTEVILLE PUBLIC WORKS COMMISSION	
<input type="checkbox"/> ORIGINAL	<input type="checkbox"/> TAPS ONLY
<input type="checkbox"/> RECORD DRAWING	<input type="checkbox"/> MODIFICATION
WO # INT:	WO # ST:
WO # WD:	WO # SD:
ENG TECH:	PERMIT #:
REVIEWED BY: <i>[Signature]</i>	PERMIT #:
DATE: 4/11/2022	DWG #:
WRFP #:	# OF SHEETS:

DATE	REVISIONS

DATE: 4/11/2022	SURVEY/GPS BY: PWC
DRAWN BY: BDT/WJD	CHECKED BY:
HOR: 1"=30'	VERT: 1"=3'



RIVER ROAD
SANITARY SEWER MANHOLE REPLACEMENT
AT CARGILL

FAYETTEVILLE PUBLIC WORKS COMMISSION
FAYETTEVILLE WATER RESOURCES ENGINEERING
P.O. Box 1888, Fayetteville, NC 28302
955 Old Wilmington Road, Fayetteville, NC 28301

